



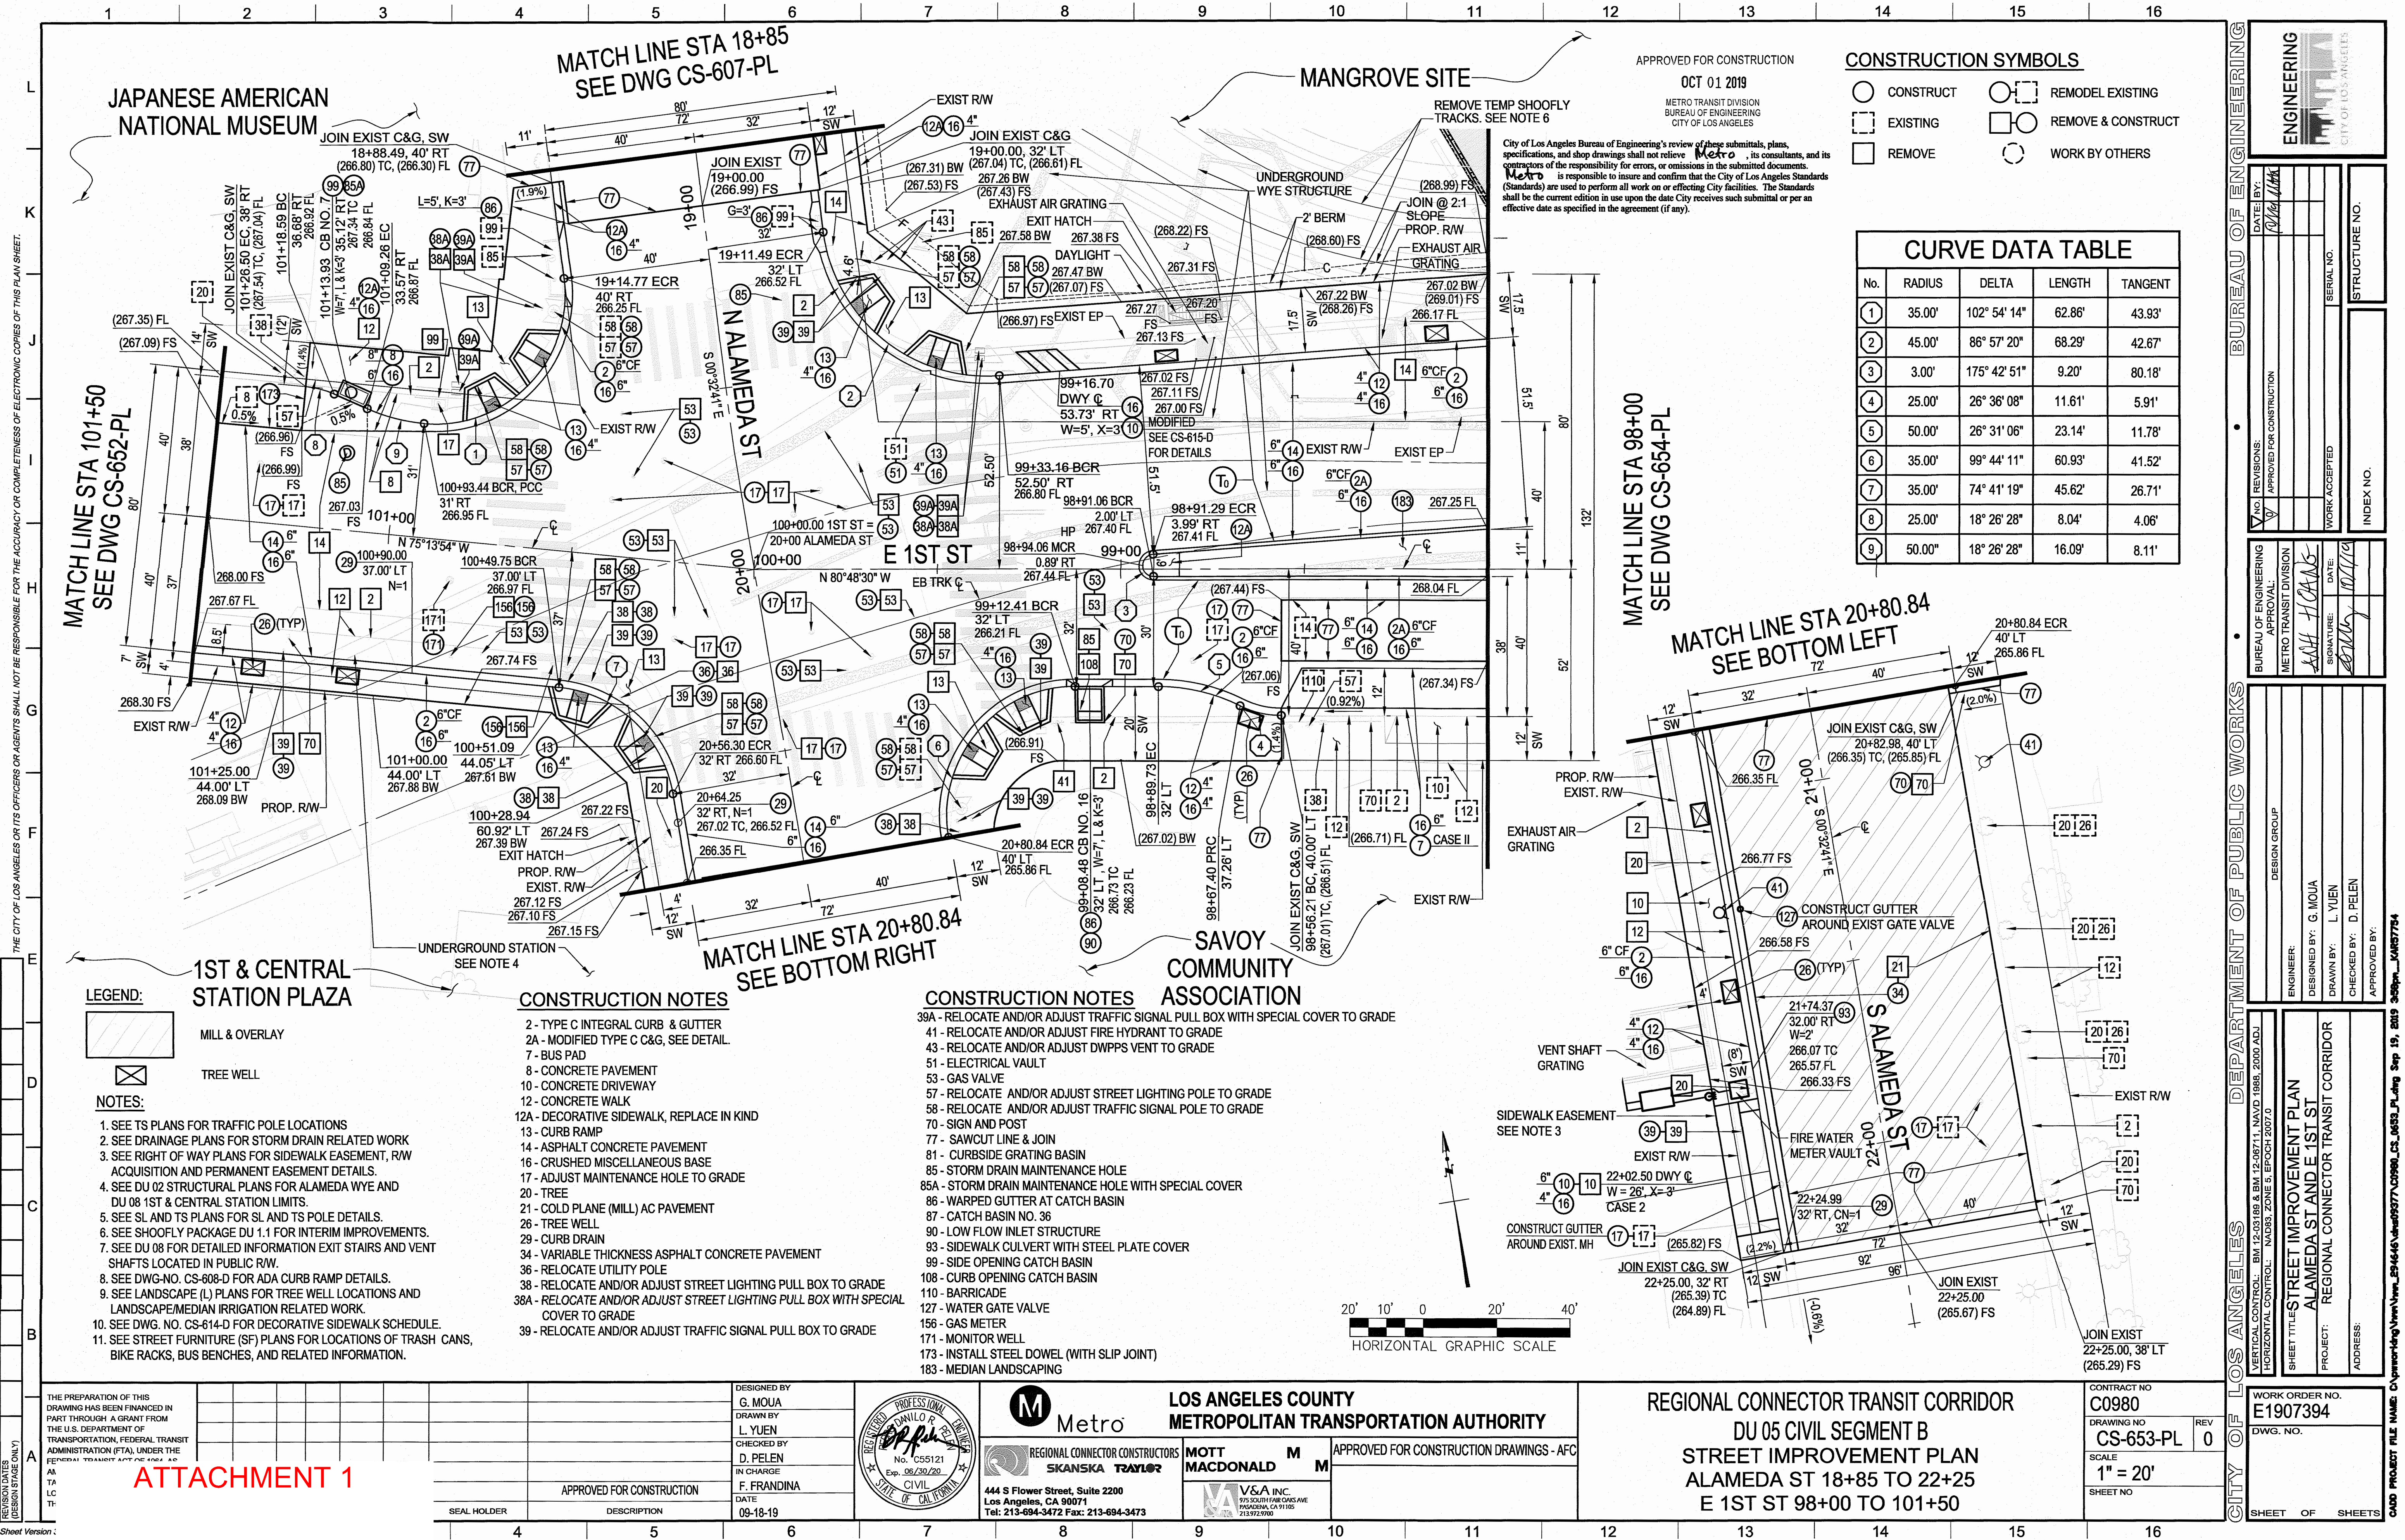

ATTACHMENT 1

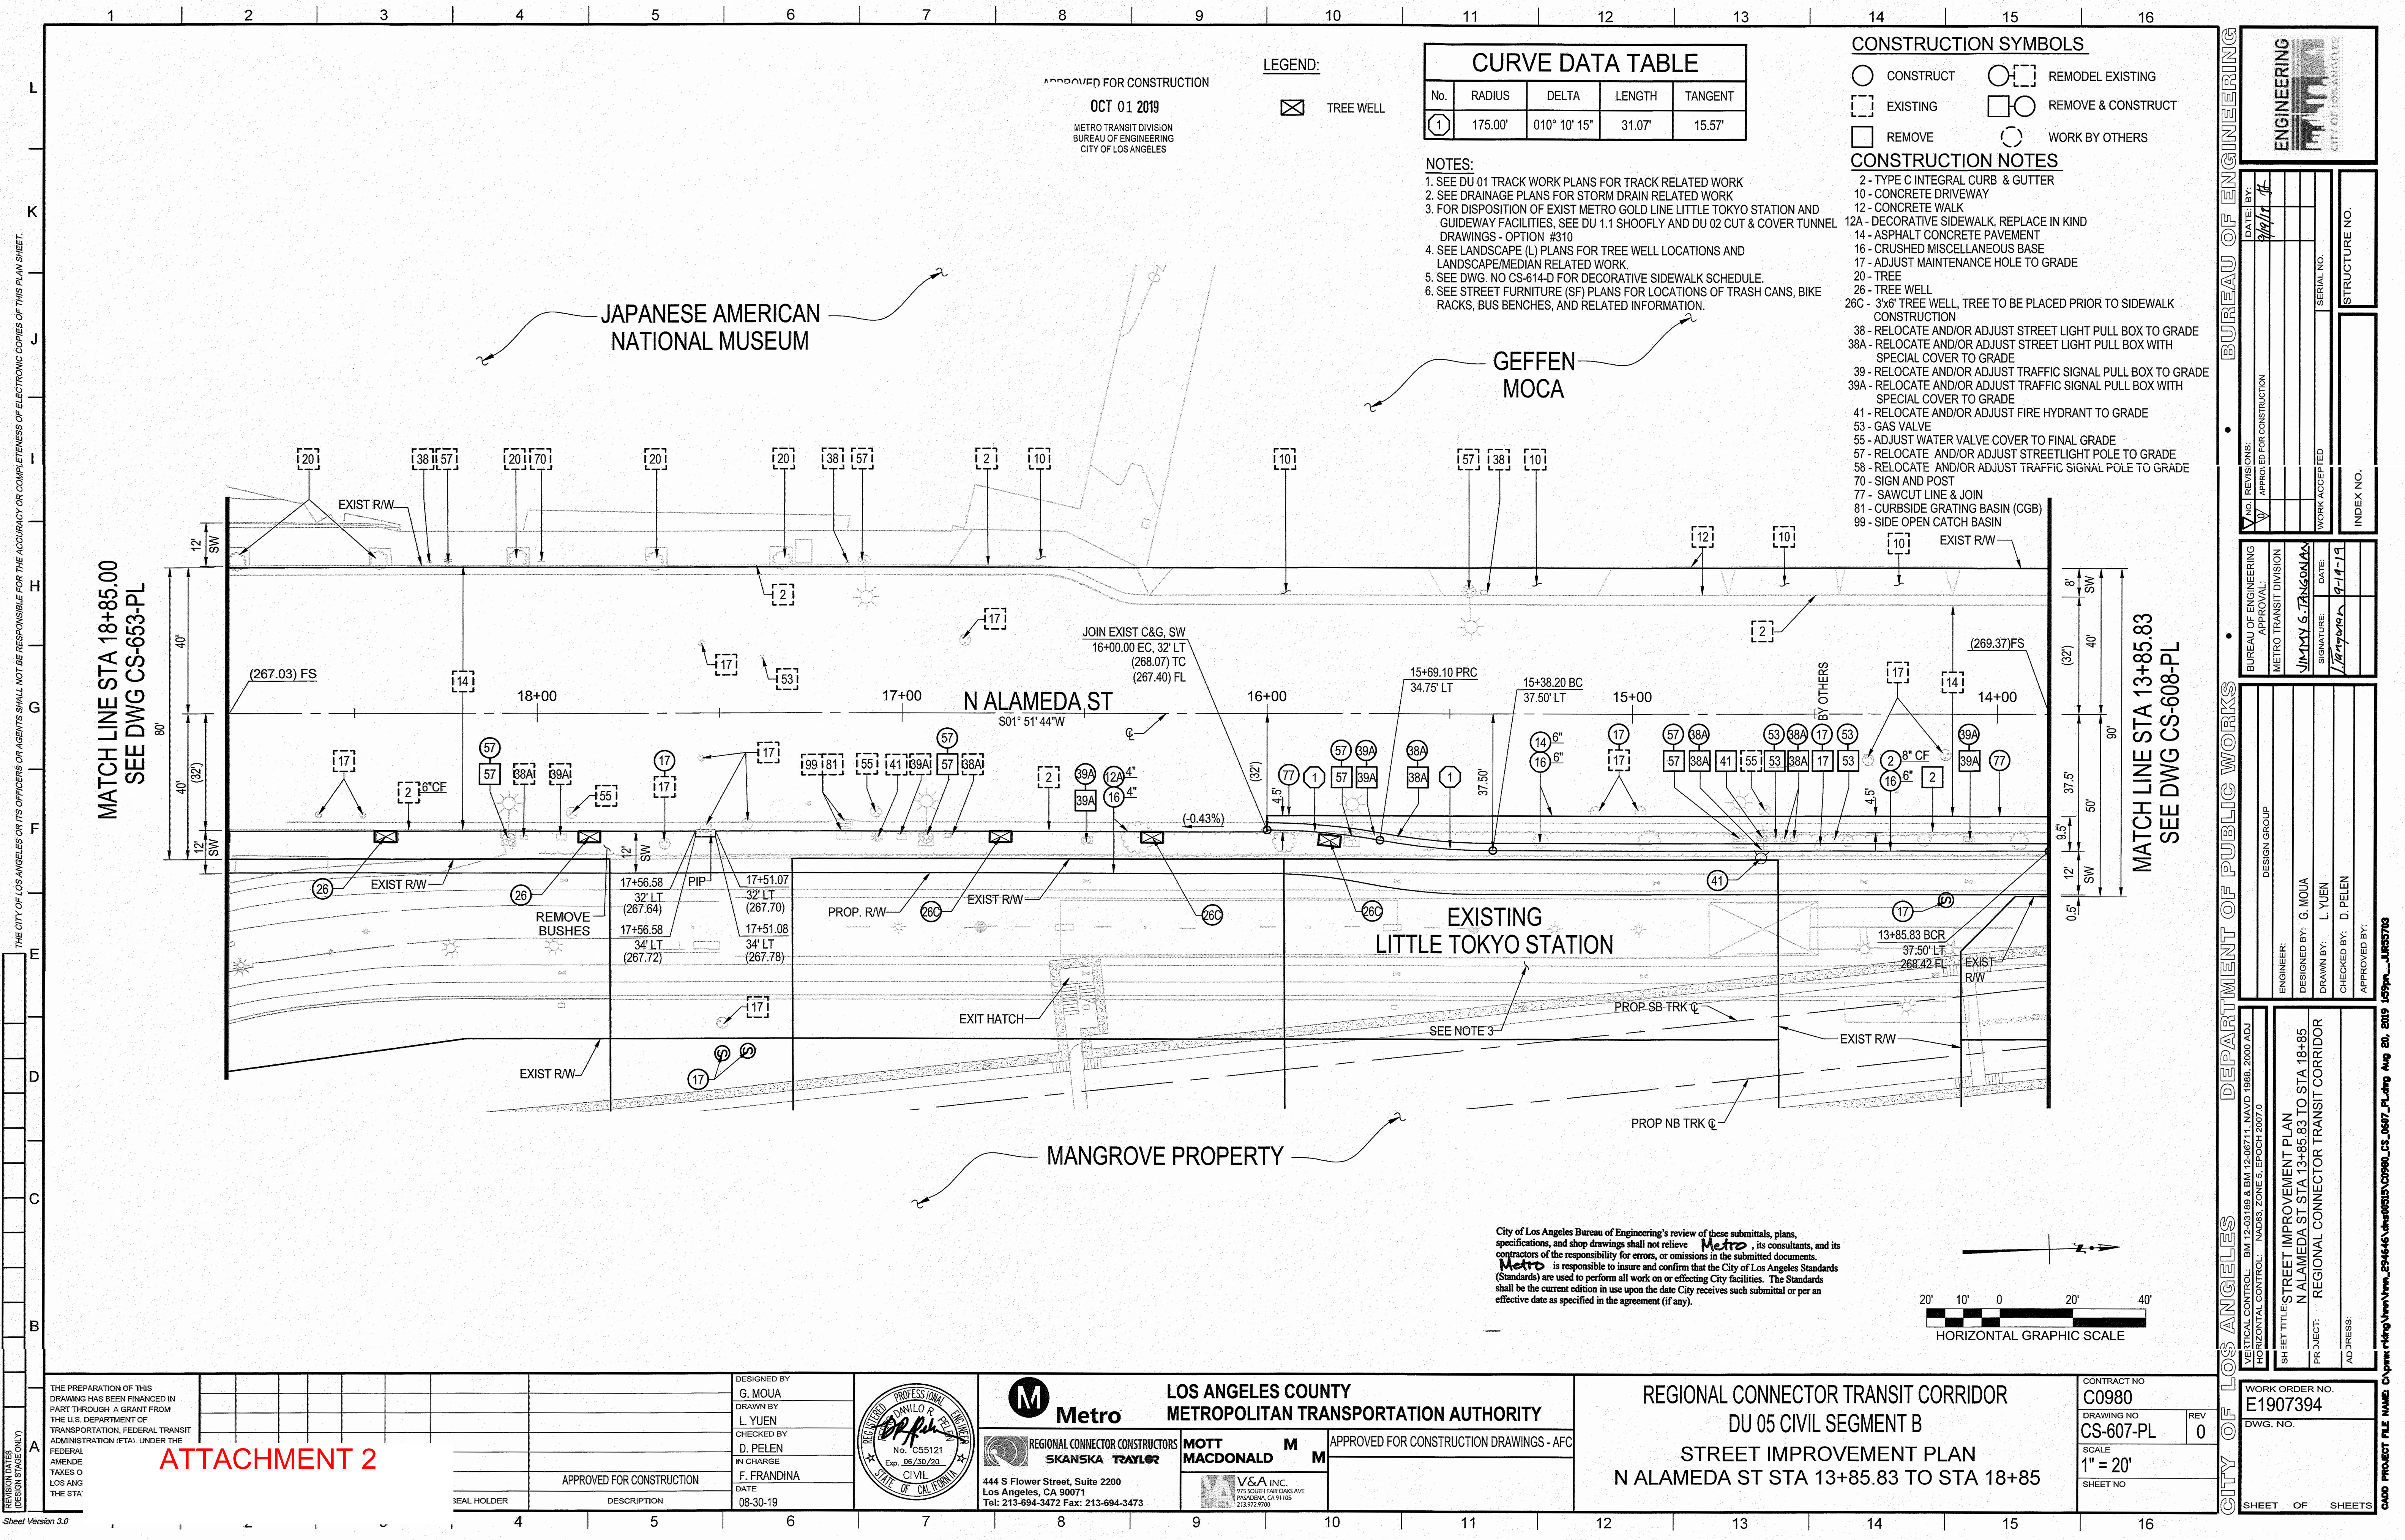

LEGEND:
[Symbol] TREE WELL

CURVE DATA TABLE				
No.	RADIUS	DELTA	LENGTH	TANGENT
1	175.00'	010° 10' 15"	31.07'	15.57'

- NOTES:
- SEE DU 01 TRACK WORK PLANS FOR TRACK RELATED WORK
 - SEE DRAINAGE PLANS FOR STORM DRAIN RELATED WORK
 - FOR DISPOSITION OF EXIST METRO GOLD LINE LITTLE TOKYO STATION AND GUIDEWAY FACILITIES, SEE DU 1.1 SHOOFLY AND DU 02 CUT & COVER TUNNEL DRAWINGS - OPTION #310
 - SEE LANDSCAPE (L) PLANS FOR TREE WELL LOCATIONS AND LANDSCAPE/MEDIAN RELATED WORK
 - SEE DWG. NO CS-614-D FOR DECORATIVE SIDEWALK SCHEDULE
 - SEE STREET FURNITURE (SF) PLANS FOR LOCATIONS OF TRASH CANS, BIKE RACKS, BUS BENCHES, AND RELATED INFORMATION

- CONSTRUCTION SYMBOLS
- [Symbol] CONSTRUCT
 - [Symbol] REMODEL EXISTING
 - [Symbol] EXISTING
 - [Symbol] REMOVE & CONSTRUCT
 - [Symbol] REMOVE
 - [Symbol] WORK BY OTHERS

- CONSTRUCTION NOTES
- TYPE C INTEGRAL CURB & GUTTER
 - CONCRETE DRIVEWAY
 - CONCRETE WALK
 - DECORATIVE SIDEWALK, REPLACE IN KIND
 - ASPHALT CONCRETE PAVEMENT
 - CRUSHED MISCELLANEOUS BASE
 - ADJUST MAINTENANCE HOLE TO GRADE
 - TREE
 - TREE WELL
 - 3x6' TREE WELL, TREE TO BE PLACED PRIOR TO SIDEWALK CONSTRUCTION
 - RELOCATE AND/OR ADJUST STREET LIGHT PULL BOX TO GRADE
 - RELOCATE AND/OR ADJUST STREET LIGHT PULL BOX WITH SPECIAL COVER TO GRADE
 - RELOCATE AND/OR ADJUST TRAFFIC SIGNAL PULL BOX TO GRADE
 - RELOCATE AND/OR ADJUST TRAFFIC SIGNAL PULL BOX WITH SPECIAL COVER TO GRADE
 - RELOCATE AND/OR ADJUST FIRE HYDRANT TO GRADE
 - GAS VALVE
 - ADJUST WATER VALVE COVER TO FINAL GRADE
 - RELOCATE AND/OR ADJUST STREETLIGHT POLE TO GRADE
 - RELOCATE AND/OR ADJUST TRAFFIC SIGNAL POLE TO GRADE
 - SIGN AND POST
 - SAWCUT LINE & JOIN
 - CURBSIDE GRATING BASIN (CGB)
 - SIDE OPEN CATCH BASIN

ENGINEERING

CITY OF LOS ANGELES

DATE BY: 9/14/19

APPROVED FOR CONSTRUCTION

SERIAL NO.

STRUCTURE NO.

INDEX NO.

BUREAU OF ENGINEERING

METRO TRANSIT DIVISION

APPROVAL

DESIGNED BY: G. MOUA

DRAWN BY: L. YUEN

CHECKED BY: D. PELEN

APPROVED BY:

VERTICAL CONTROL: BM 12-03189 & BM 12-06711, NAVD 1988, 2000 ADJ

HORIZONTAL CONTROL: NAD83, ZONE 5, EPOCH 2007.0

SHEET TITLE: STREET IMPROVEMENT PLAN

PROJECT: N ALAMEDA ST STA 13+85.83 TO STA 18+85

REGIONAL CONNECTOR TRANSIT CORRIDOR

AD JESS:

CONTRACT NO. C0980

DRAWING NO. CS-607-PL

SCALE 1" = 20'

SHEET NO.

WORK ORDER NO. E1907394

DWG. NO.

SHEET OF SHEETS

THE PREPARATION OF THIS DRAWING HAS BEEN FINANCED IN PART THROUGH A GRANT FROM THE U.S. DEPARTMENT OF TRANSPORTATION, FEDERAL TRANSIT ADMINISTRATION (FTA), UNDER THE FEDERAL AMENDMENT TAXES OF LOS ANGELES THE STA

ATTACHMENT 2

DESIGNED BY: G. MOUA
DRAWN BY: L. YUEN
CHECKED BY: D. PELEN
IN CHARGE: F. FRANDINA
DATE: 08-30-19

SEAL HOLDER

DESCRIPTION

APPROVED FOR CONSTRUCTION

DATE: 08-30-19

PROFESSIONAL ENGINEER

NO. CS5121

Exp. 06/30/20

CIVIL

STATE OF CALIFORNIA

Metro

REGIONAL CONNECTOR CONSTRUCTORS

SKANSKA TAYLOR

444 S Flower Street, Suite 2200

Los Angeles, CA 90071

Tel: 213-694-3472 Fax: 213-694-3473

LOS ANGELES COUNTY

METROPOLITAN TRANSPORTATION AUTHORITY

APPROVED FOR CONSTRUCTION DRAWINGS - AFC

V&A INC.

975 SOUTH FAIR OAKS AVE

PO BOX 900

90040 CA 91108

213.972.9700

REGIONAL CONNECTOR TRANSIT CORRIDOR

DU 05 CIVIL SEGMENT B

STREET IMPROVEMENT PLAN

N ALAMEDA ST STA 13+85.83 TO STA 18+85

CONTRACT NO. C0980

DRAWING NO. CS-607-PL

SCALE 1" = 20'

SHEET NO.

WORK ORDER NO. E1907394

DWG. NO.

SHEET OF SHEETS

Sheet Version 3.0